


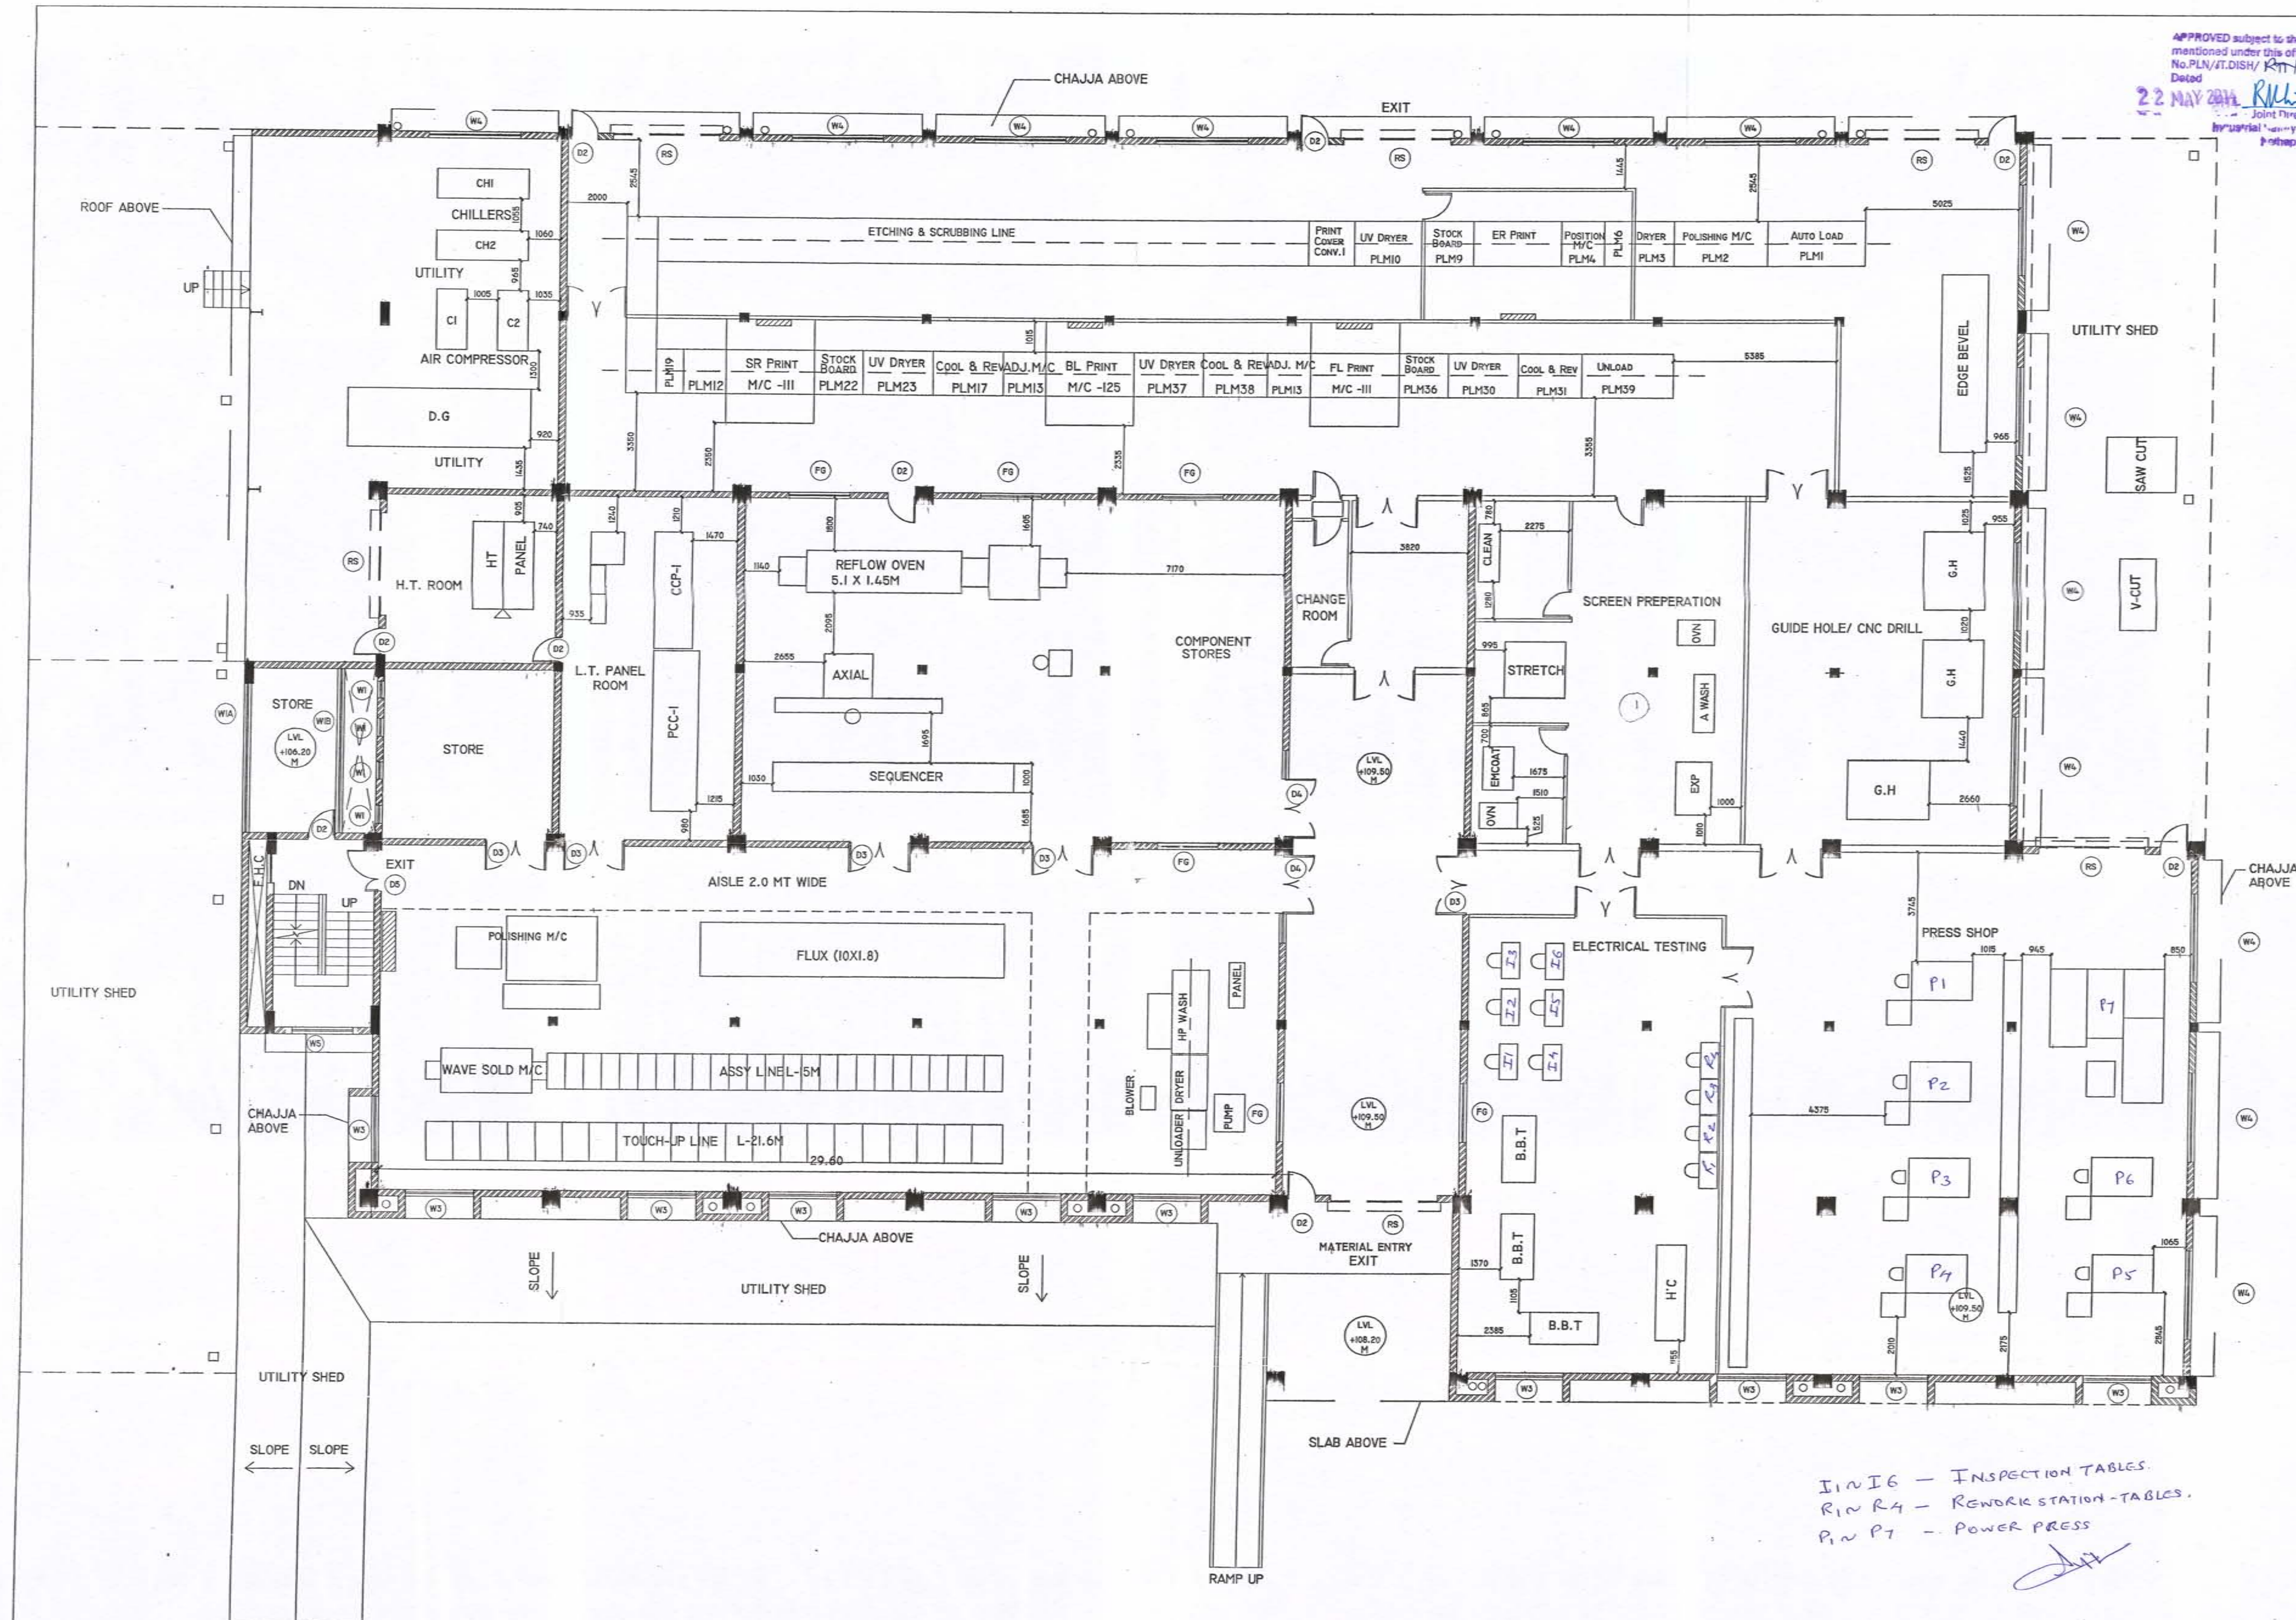

APPROVED subject to the conditions mentioned under this office letter No. PLN/IT.DISH/ RIT-22/2018/NTM/REC/1985/2014
 Dated 22 MAY 2018
 Joint Director
 Industrial Safety and Health
 Pothapur.

PERFORMA - B
 CONTENTS OF SHEET

• GROUND FLOOR PLAN

STAMP OF DATE OF RECEIPT. OF PLAN

STAMP OF DATE OF APPROVAL OF PLAN

DESCRIPTION OF PROPOSAL

PROPOSED SCHEME FOR FACTORY BUILDING OF AKASAKA ELECTRONICS ON PLOT BEARING NUMBER G-1, MIDC, LOTE PARSHURAM INDUSTRIAL ESTATE, TALUKA - KHED, DISTRICT - RATNAGIRI

JOB NO.	DRG. NO.	SCALE	DATE	DRN
	F-3	1:100	29-09-13	

NAME AND SIGN. OF OWNER

M/S AKASAKA ELECTRONICS LTD.

For Akasaka Electronics Ltd.

Authorised Signatory

NAME OF THE ARCHITECT

HADRIAN LOBO
 ARCHITECTS, INTERIOR DESIGNERS
 A-604, MERCURY, SUNCITY COMPLEX,
 ADI SHANKARACHARYA MARG, POWAI,
 MUMBAI 400 076

HADRIAN LOBO

A-604, MERCURY
 SUNCITY COMPLEX
 POWAI, MUMBAI 400076

NAME OF THE STRUCTURAL CONSULTANT

S.W. MONE & ASSOCIATES
 CONSULTING ENGINEERS
 3, SHAROP COMPLEX, 2ND FLOOR,
 KARVE ROAD, PUNE 411 004

I.N.I.G - INSPECTION TABLES
 R.W.R. - REWORK STATION - TABLES
 P.W.P. - POWER PRESS